

NOTES:

ALL TRENCHES IN EXPOSED ROCK TO BE LINED WITH LIQUID BITUMEN SPRAY IMMEDIATELY AFTER EXPOSURE.

1. DO NOT SCALE. USE FIGURED DIMENSIONS ONLY.


THIS DRAWING IS TO BE READ IN CONJUNCTION WITH ALL OTHER RELEVANT ARCHITECTURAL AND ENGINEERING DRAWINGS.

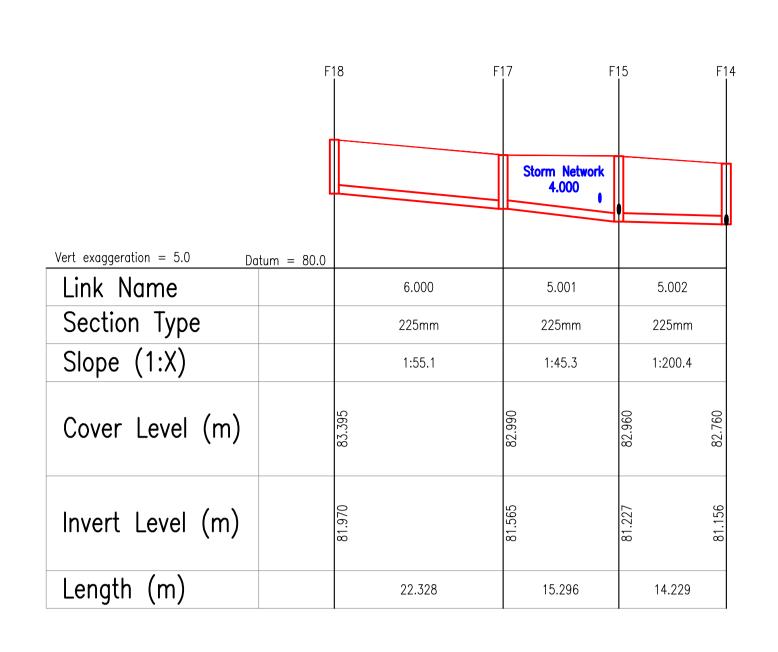


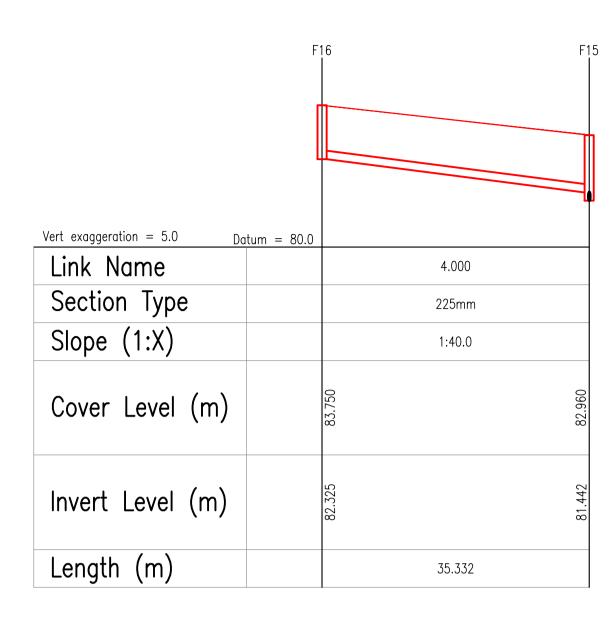

	FMI	13A I	F3 I
Vert exaggeration = 5.0 Da	tum = 81.0		
Link Name		3.000_1	
Section Type		150mm	
Slope (1:X)		1:59.7	
Cover Level (m)		84.625	84.895
Invert Level (m)		83.225	83.028
Length (m)		11.762	
			•

	FW-	-2.1	F
		Storm Network (	
Vert exaggeration = 5.0 po	atum = 81.0	5.003	, 4
Link Name	3.10	7.000	
Section Type		150mm	
Slope (1:X)		1:60.0	
Cover Level (m)		84.789	84.895
Invert Level (m)		83.439	83.156
Length (m)		17.003	

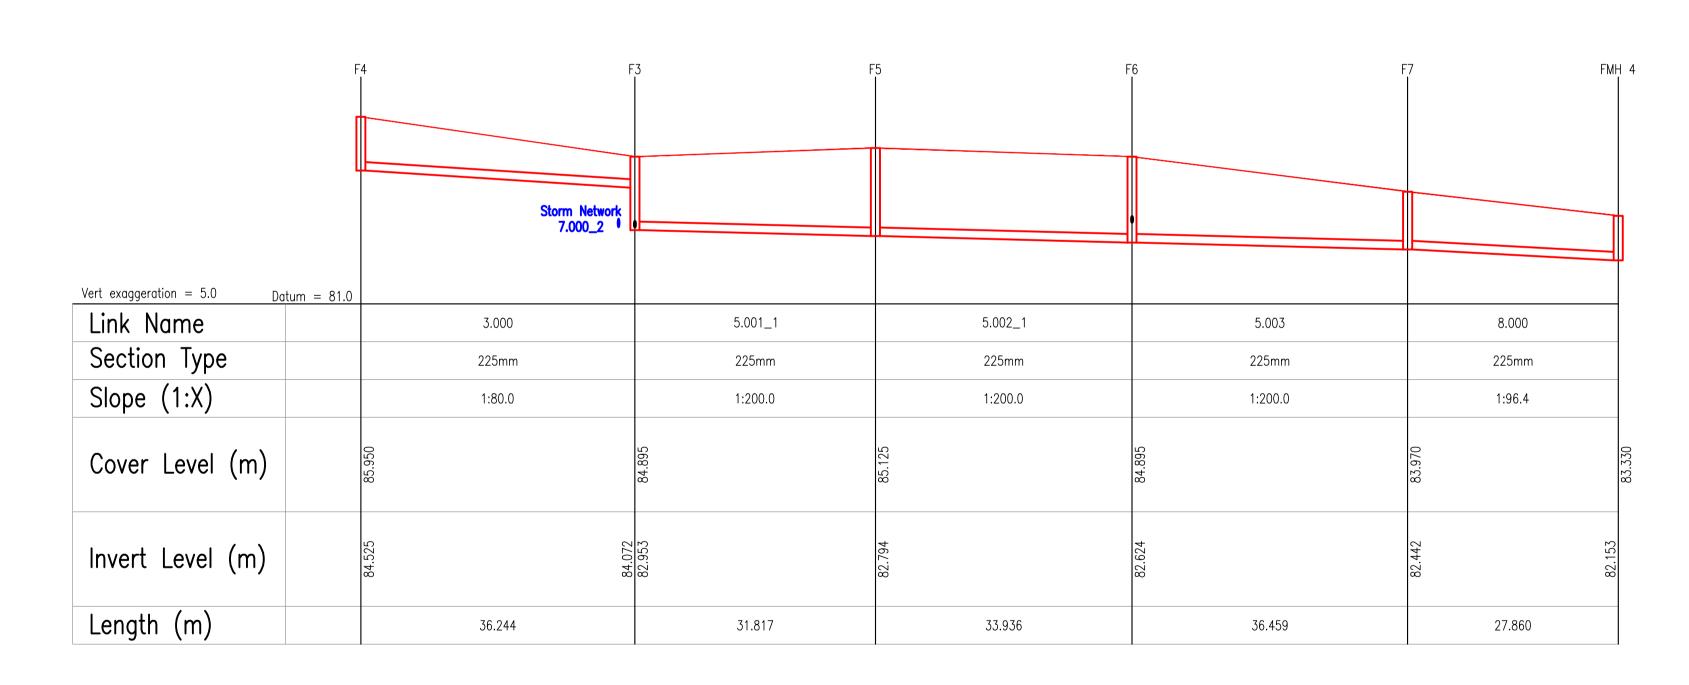

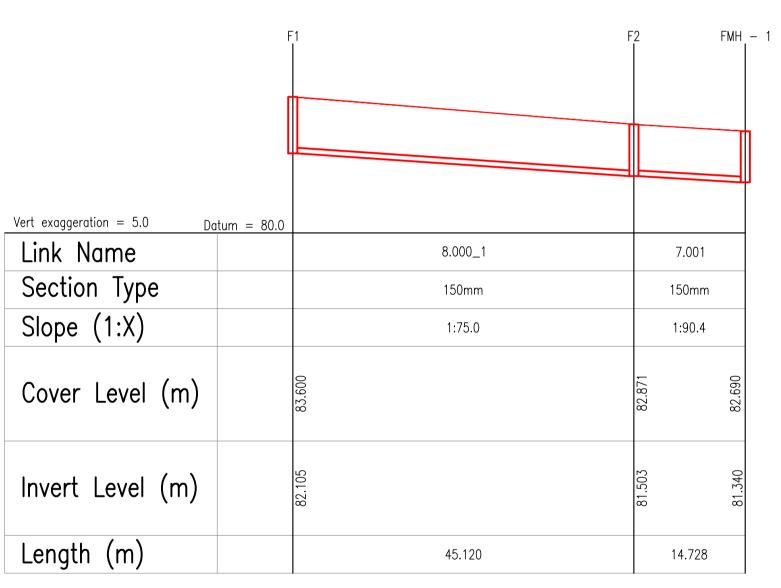

REF: CDS23001981

REFER TO DRAWING 20-074-T4200 FOR THE PLAN VIEW OF THE DRAINAGE LAYOUT

STATU	IS	EOD DI ANNING		
REV.	DATE	AMENDMENT	DRN	APPD
_	31/ 05/ 23	ISSUED FOR PLANNING	MS	IW



BLOCK S, EASTPOINT BUSINESS PARK, ALFIE BYRNE ROAD, DUBLIN D03 H3F4 IRELAND. Tel: (01) 664 8900 Email: info@waterman-moylan.ie www.waterman-moylan.ie

FOR PLANNING

CLIENT	FINGAL COUNTY COUNCIL			
ARCHITECT	WALSH & ASSOCIATES			
PROJECT	CHURCH FIELDS	EAST		
TITLE	FOUL LONG SEC	tions — Sheet 2	? OF 2	
DRAWN <b>MS</b>	DESIGNED <b>JB</b>	APPROVED IW	DATE <b>MAY 2023</b>	
SCALE	JOB NO.	DRG. NO.	REVISION	

May 30, 2023 - 4:26pm Drawing Location: \wmfilesvr\Moylan\Projects\20\20-074 - Churchfields\Drawings\Waterman Moylan\Civil\Planning - Church Fields East Sector 4\Sector 4\Sector 4\20-074 - P4230-P4240 - Foul and Surface Water Longsections.dwg